 




09/19/2019 11:59:37 AM
 BAR MEASURE 1" = 80'
 FILE: G:\15310-WAUKESHA GREAT LAKES WATER SUPPLY PM-CM21 CADD\21.05 WORKING DWGS\CONTRACT PACKAGE 3 - BPSF\GLWSP-P3-BPSF-BC01A-NEW-BERLIN.DWG

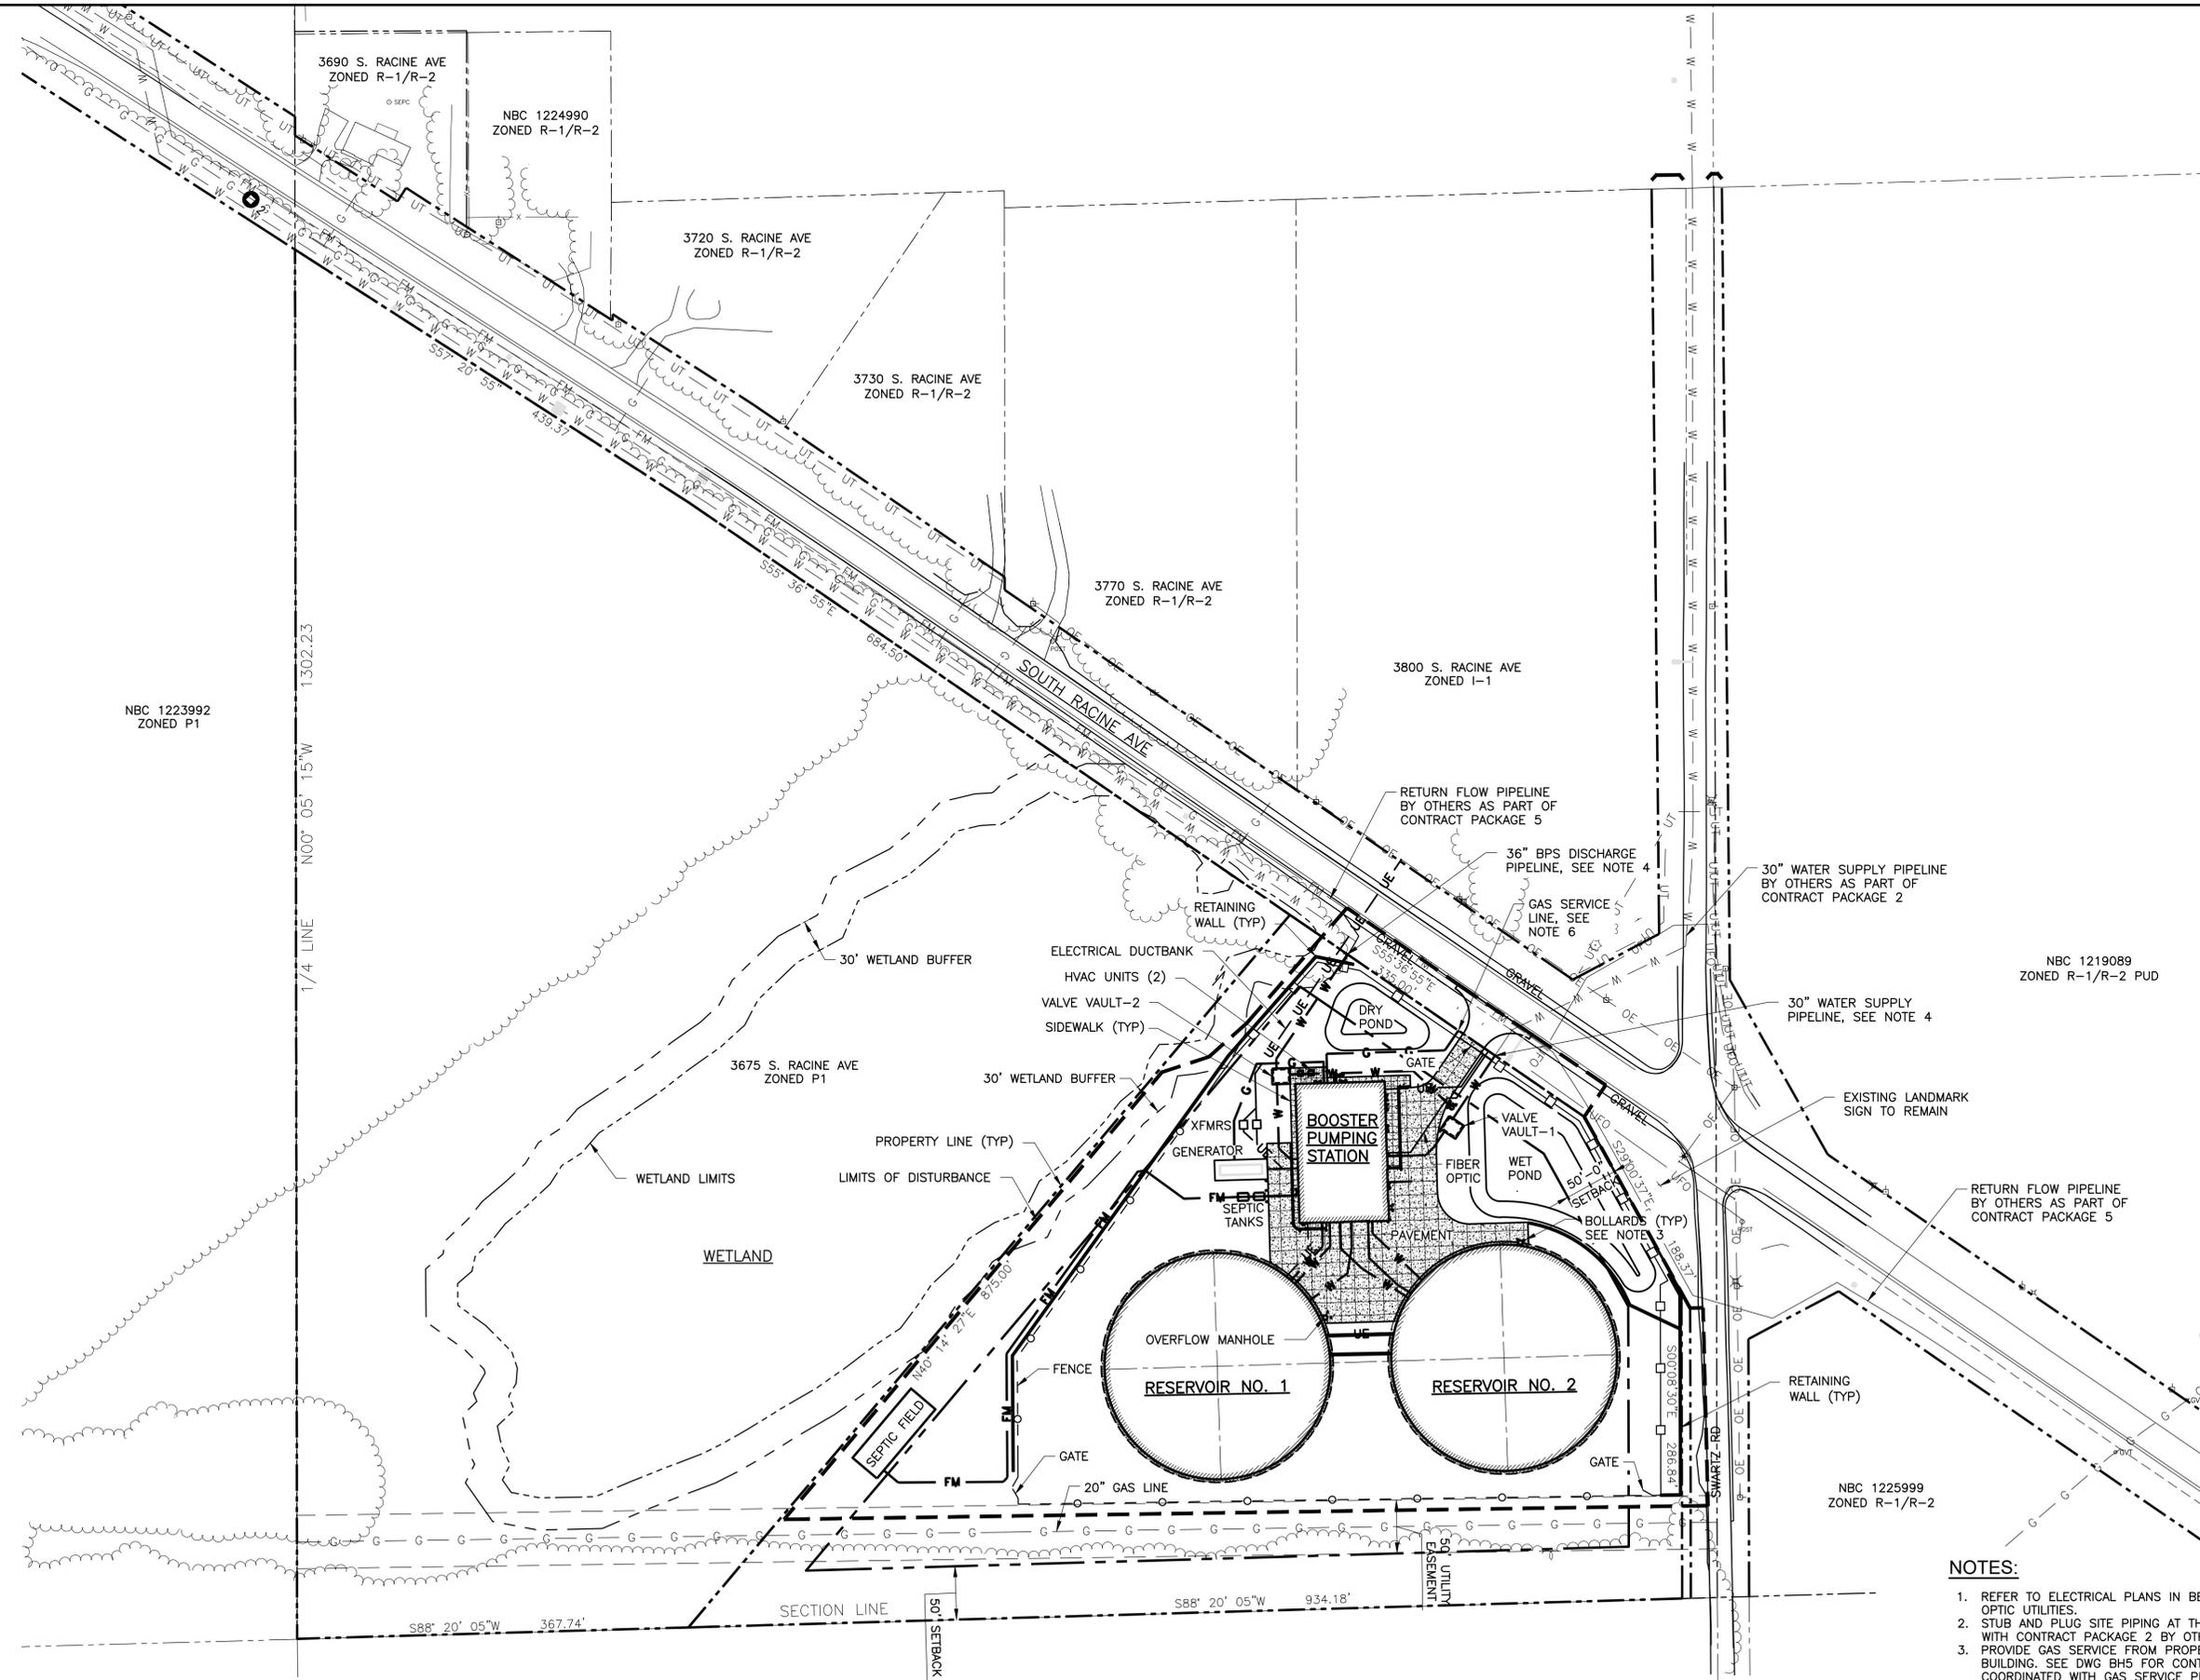

DRAFT 98% PROGRESS DRAWINGS
 SEPTEMBER 2019

NEW SITE PLAN
 SCALE: 1" = 80'

 - NOTES:**
1. REFER TO ELECTRICAL PLANS IN BE DWGS FOR ELECTRICAL AND FIBER OPTIC UTILITIES.
 2. STUB AND PLUG SITE PIPING AT THE PROPERTY LINE FOR CONNECTION WITH CONTRACT PACKAGE 2 BY OTHERS.
 3. PROVIDE GAS SERVICE FROM PROPERTY LINE TO WITHIN 5 FEET OF BUILDING. SEE DWG BH5 FOR CONTINUATION. ALL WORK TO BE COORDINATED WITH GAS SERVICE PROVIDER.



GREAT WATER ALLIANCE <small>CONTRACT PACKAGE 3: BOOSTER PUMPING STATION AND WATER SUPPLY CONTROL BUILDING</small>		NEW SITE PLAN	
APPROVED _____ SEAL AFFIXED MONTH / DAY / YEAR SEPTEMBER 2019			
JOB NO.: 15310			
DESIGN	LAM	CHCK	RMC
APPRV	AJM	DRWN	LG
SCALE: AS SHOWN			
DRAWING NUMBER			
BC1A			
SHEET 51 OF 181		REV 0	